

RESPONSIBILITY IS NOT ACCEPTED FOR OTHERS SCALING DIRECTLY FROM THIS DRAWING. DO NOT SCALE FROM THIS DRAWING. USE WRITTEN DIMENSIONS ONLY.


0 0.5m 1m 2m ORIGINAL SHEET SIZE **A3**

**1:50**

THIS DRAWING IS PRODUCED FOR USE IN THIS PROJECT ONLY AND MAY NOT BE USED FOR ANY OTHER PURPOSE. NPS PROPERTY CONSULTANTS LTD ACCEPT NO LIABILITY FOR THE USE OF THIS DRAWING OTHER THAN THE PURPOSE FOR WHICH IT WAS INTENDED IN CONNECTION WITH THIS PROJECT AS RECORDED IN THE 'PURPOSE FOR ISSUE' AND 'FILE STATUS CODE'.

THIS DRAWING MAY NOT BE REPRODUCED IN ANY FORM WITHOUT PRIOR WRITTEN AGREEMENT.

© CROWN COPYRIGHT AND DATABASE RIGHTS 2019 ORDNANCE SURVEY LICENCE NUMBER: 100019340.

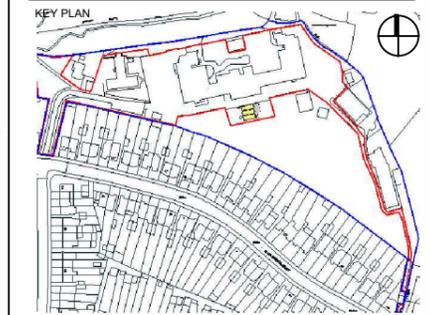

Notes:

GIA - 75m<sup>2</sup>  
 Gas cage - 0.4m<sup>2</sup>  
 Ramp and surface - 32m<sup>2</sup>  
 Waste tank 10L

FIRST ISSUE						
REV	DATE	CHECKED	DATE	APPROVED	DATE	
P2	DA	30.01.25	TN	30.01.25	RA	30.01.25
FIRST ISSUE						
P1	DA	13.11.25	TN	13.11.25	RA	13.11.25

**EVOLVE**  
 A PARTNERSHIP BETWEEN  
 WALTHAM FOREST COUNCIL AND NORSE CONSULTING

Evolve Norse  
 280 Filers Lane, Norwich, NR6 6EQ  
 Tel: 01603 894100 web:www.norsegroup.co.uk

CLIENT  
**LBWF**



PROJECT  
**Yardley PS 1FE Expansion, Hawkwood Crescent, E4 7PH**

TITLE  
**Temporary Kitchen floor plan**

SCALE 1:50 DISCIPLINE Architect PROJECT NUMBER 116612

DRAWING NUMBER **EVO-ZZ-00-D-A-A-042** REV CODE **P2**

STATUS CODE **S2** PURPOSE OF ISSUE **Information** Drawn by **DA** Approved by **RA**  
 Checked by **TN**

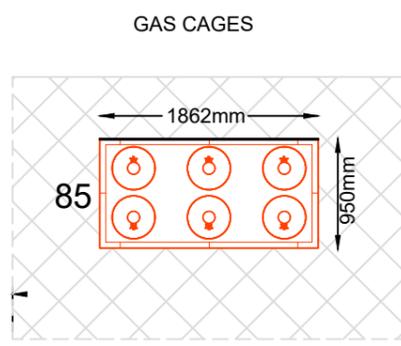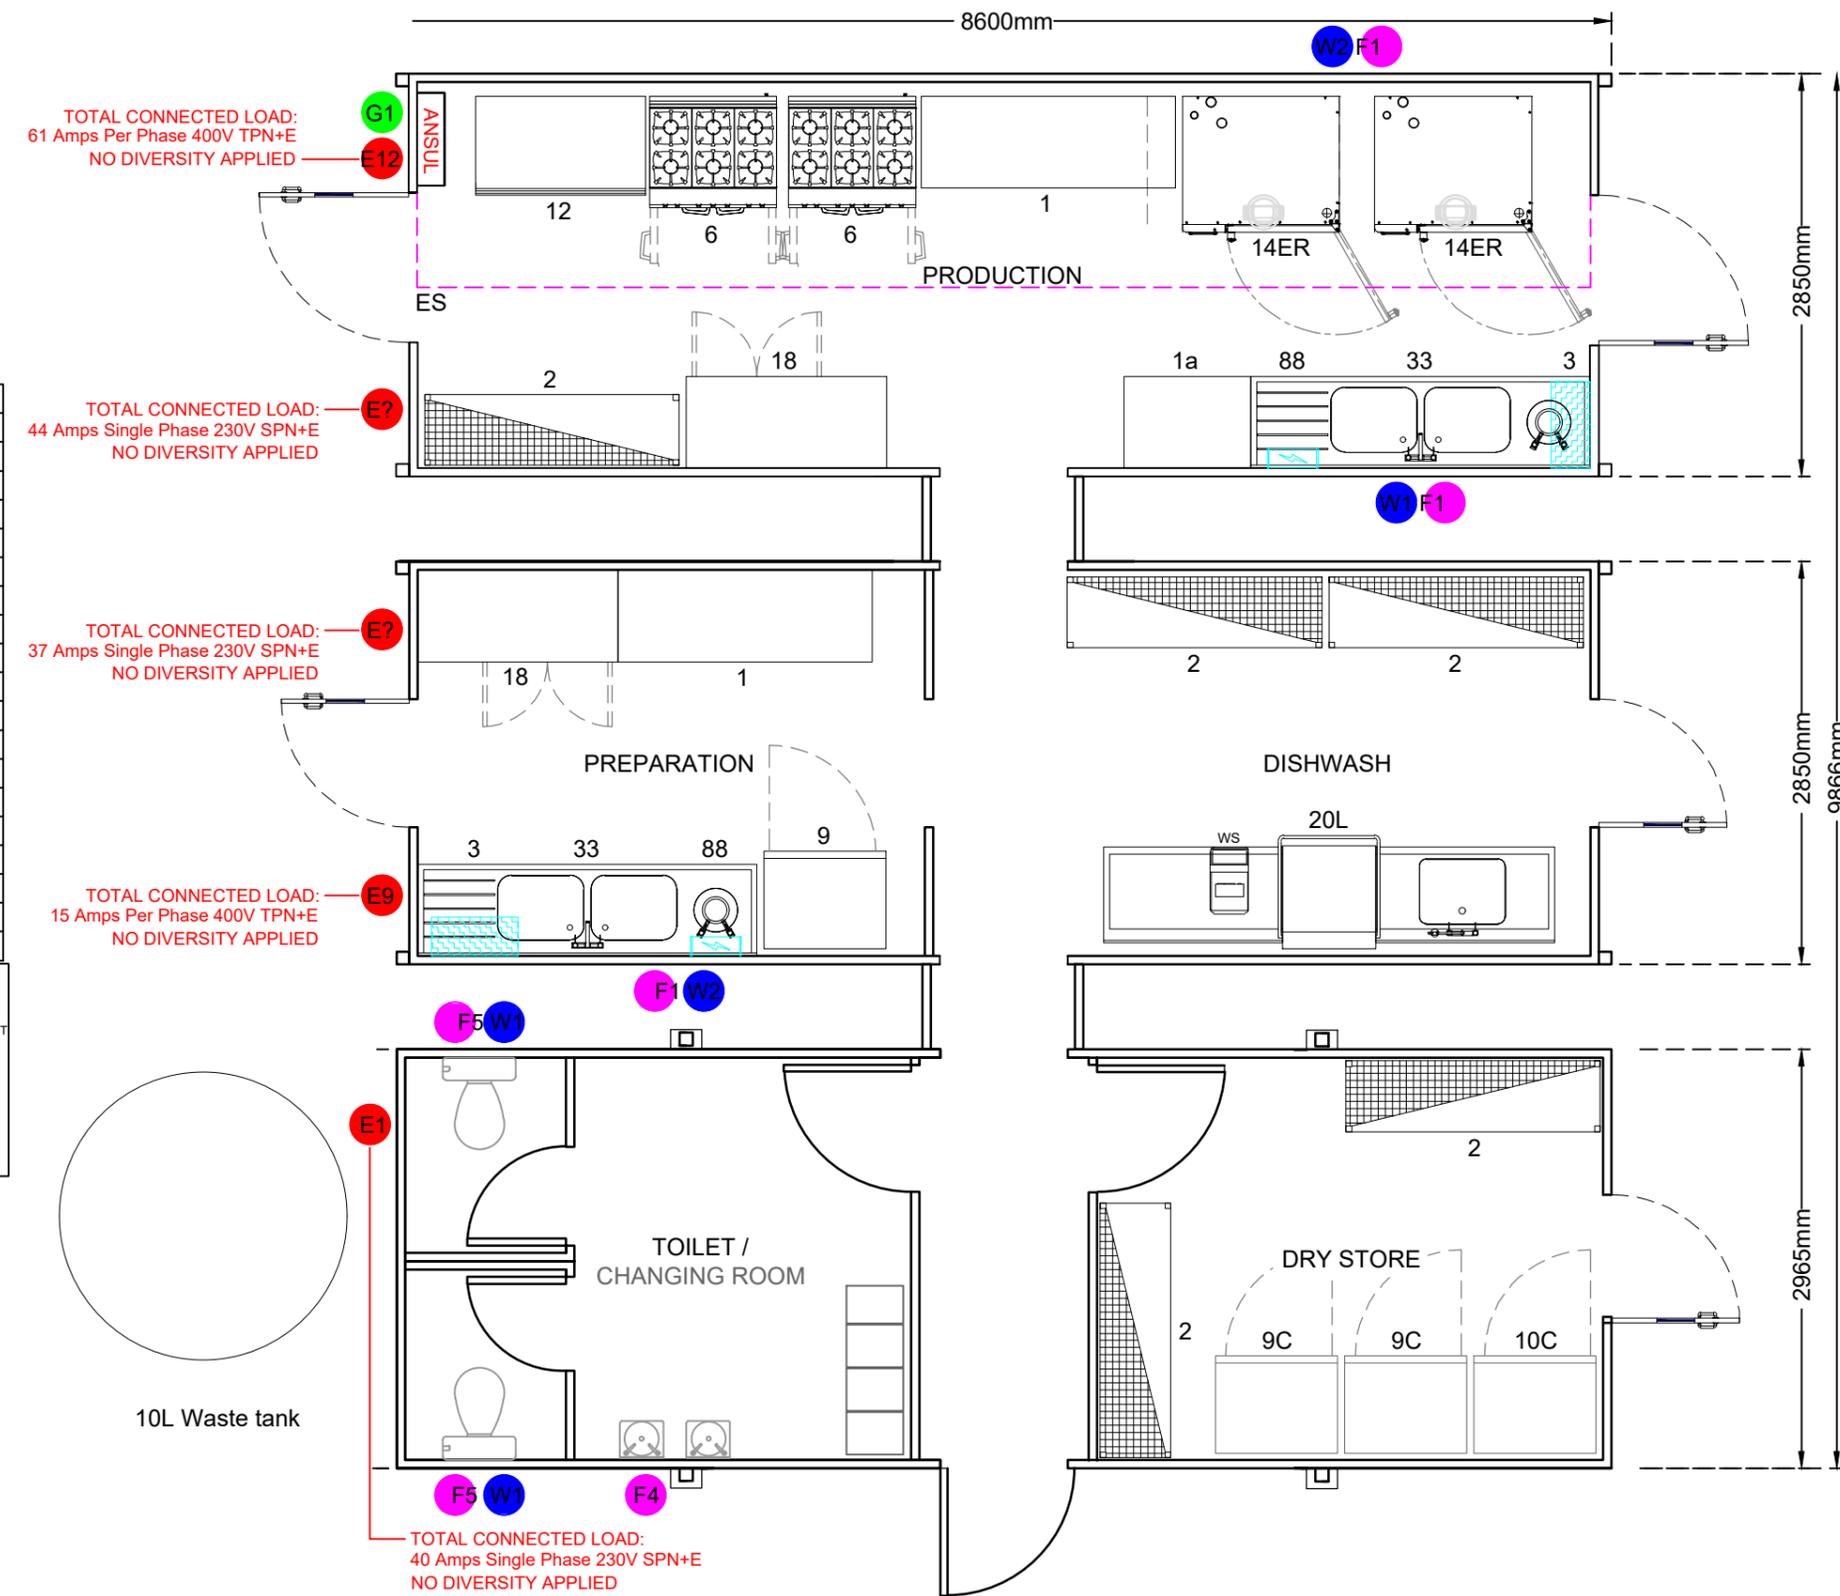

EQUIPMENT LEGEND		
ID	QTY	DESCRIPTION
1	2	PREPARATION TABLE 1800MM
10C	1	UPRIGHT FREEZER - BY CLIENT
12	1	HOTCUPBOARD 1200MM
14ER	2	COMBINATION OVEN 24 GRID - ELECTRIC
18	2	UNDERCOUNTER REFRIGERATOR
1a	1	PREPARATION TABLE 900MM
2	5	STORAGE RACKING 1800MM
20L	1	HOOD DISHWASHER 3-PHASE - LEFT TO RIGHT
3	2	WATER HEATER
33	2	DOUBLE BOWL SINK & WHB 2400MM
6	2	SIX BURNER RANGE & OVEN
85	1	GAS CAGE 6-BOTTLE
88	2	FLY KILLER
9	1	UPRIGHT REFRIGERATOR 610LT
9C	2	UPRIGHT REFRIGERATOR - BY CLIENT
CTU	2	CALCIUM TREATMENT UNIT 18LT
ES	1	EXTRACTION SYSTEM
WS1	1	WATER SOFTENER, AUTOMATIC

SERVICES KEY	
E1	63AMP SINGLE PHASE COMMANDO
E2	32AMP SINGLE PHASE COMMANDO
E3	63AMP THREE PHASE COMMANDO
E4	32AMP THREE PHASE COMMANDO
E5	13AMP SINGLE PHASE PLUG
E6	100AMP THREE PHASE HARD WIRED
E7	80AMP THREE PHASE HARD WIRED
E8	16AMP SINGLE PHASE COMMANDO
E9	16AMP THREE PHASE COMMANDO
E10	100AMP SINGLE PHASE HARDWIRED
E11	125AMP SINGLE PHASE COMMANDO
E12	125AMP THREE PHASE HARDWIRED
E13	250AMP THREE PHASE HARDWIRED
E?	63AMP OR 125AMP SINGLE PHASE CONNECTION DEPENDING ON THE FINAL ALLOCATION OF UNITS
F1	40MM BSP WASTE OUTLET
F2	100MM BSP FOUL WASTE OUTLET
F3	50MM BSP WASTE OUTLET
F4	32MM BSP WASTE OUTLET
F5	110MM BSP WASTE OUTLET
G1	NAT GAS / LPG INLET
W1	15MM BSP WATER INLET
W2	22MM BSP WATER INLET
W3	22MM BSP HOT WATER INLET
W4	15MM BSP HOT WATER INLET

