
 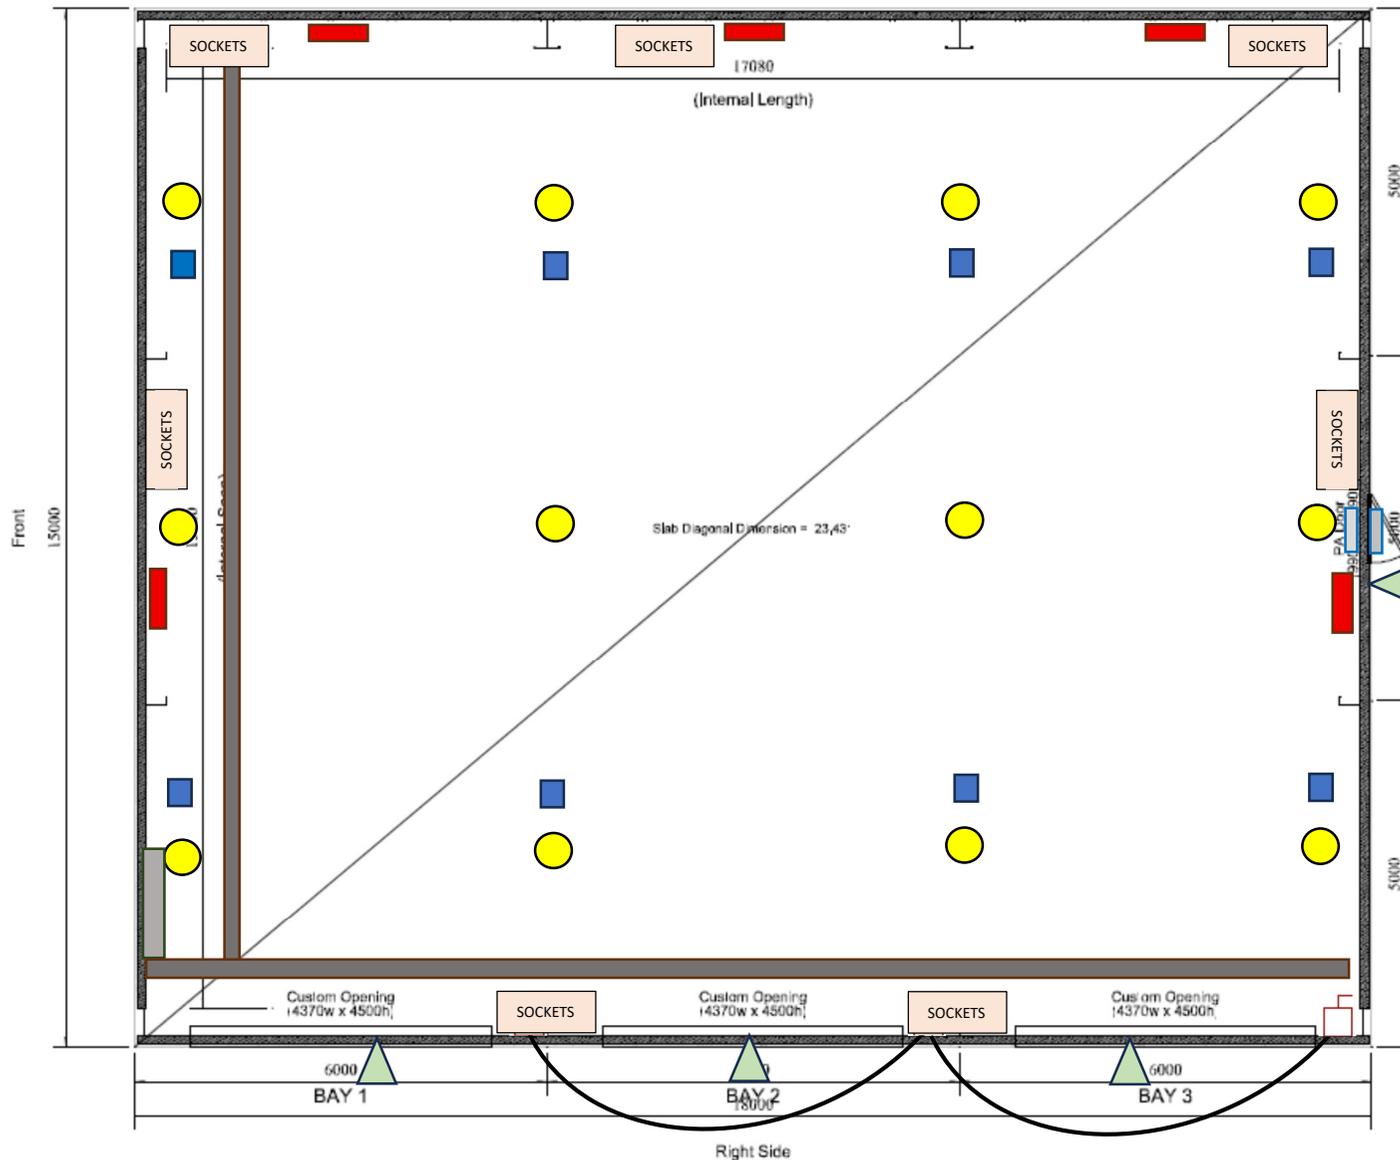


Left Side



SYMBOL LEGEND

-  Hi-bay LED lighting (12Nr)
-  High Powered Emergency Lights (8Nr)
-  Overdoor Emergency/Exit Light (By-Others)
-  Schneider TP16 Distribution Board
-  Main/Central Containment Tray
-  Power/Isolator's For Electric Roller Shutters (Door Controls positioned immediately below)
-  Dimplex QXD3000E Wall Heaters (5Nr)
-  External Floodlights (4Nr) Placed centrally above roller shutter doors and personnel door
-  Provision Of Power Sockets (7Nr)
2Nr Double 240V Sockets
1Nr 110V Socket
1Nr 3Ph 64A Socket For Lifters

CADMAN Construction Ltd

Cadman House, Peartree Rd
Colchester, CO3 0NW

Tel 01206 562474 Fax 01206 769203

PROJECT

Temporary Vehicle Workshop Building

TITLE

Indicative Electrical Layout (Inc Fit-Out)

Low Hall Depot, London, E17 7AS

DRAWN DESIGNED CHECKED

DATE SCALE STATUS

08430 - TW-E-01

A